


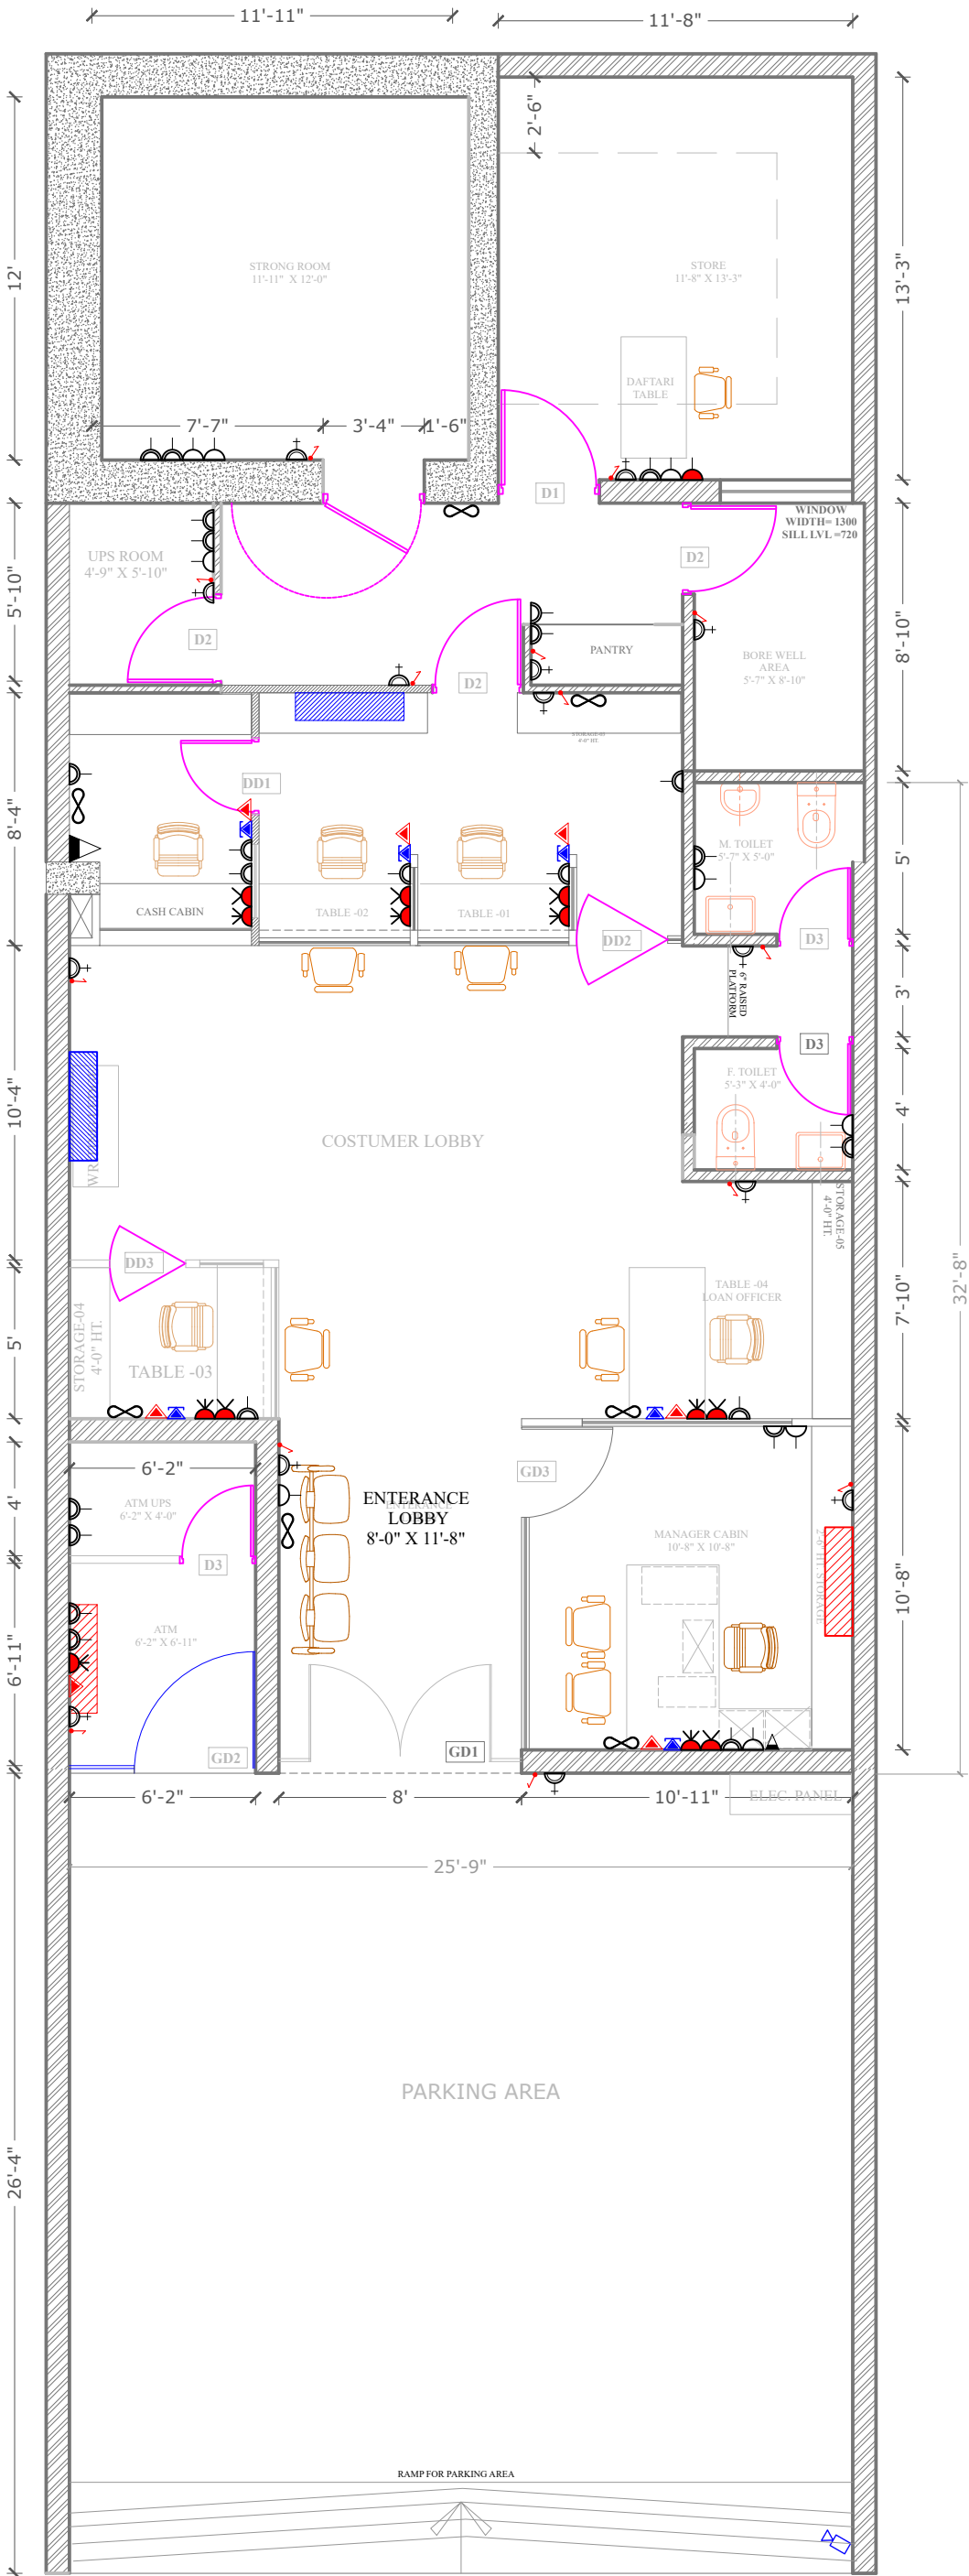

ELECTRICAL LEGENDS

LEGENDS	DESCRIPTION	NO.	LVL. ABOVE FFL
	3 -6A with 16A SWITCH (UPS)	7	300 mm (unless specified otherwise)
	2 -6A with 16A SWITCH (UPS)	6	300 mm (unless specified otherwise)
	1 -6A with 6A SWITCH (UPS)	1	900 mm (above working counter)
	1 -16A with 16A SWITCH	22	900 mm (above working counter)
	1 -6A with 6A SWITCH	10	900 mm (above working counter)
	6A SWITCH & PLUG POINT IN SWITCHBOARD	13	On Wall / partition at 1200mm above FFL
	6A ONE WAY SWITCH BOARD	13	On Wall / partition at 1200mm above FFL
	16A -5PIN PLUG & SOCKET WITH 32AMP MCB	5	As per A/C requirement
	WALL MOUNTED FAN	7	2100 mm (unless specified otherwise)
	TELEPHONE OUTLET	6	900 mm (above working counter)
	CALL BELL/PANIC SWITCH	2	900 mm (above working counter)
	EXHAUST FAN	3	
	1 TONNE AC UNITS	3	As per A/C requirement
	2 TONNE AC UNITS	2	As per A/C requirement
	DATA NETWORKING	7	900 mm (above working counter)

- GENERAL NOTES
- Do not scale the drawing follow only figured dimensions.
 - All Structural Drawings should be read in conjunction with relevant Architectural Drawings.
 - Any Discrepancy or Ambiguity in drawings should be brought to the Architect's notice immediately prior to Construction at Site.
 - All Dimensions and levels are in mm unless noted otherwise.
 - All Dimensions are from unfinished to unfinished levels unless otherwise specified.
 - Any irregularities in Construction which occurs as a result of discrepancy between Architecture, Structure, MEP, other drawings, which have not been brought to the Architects notice prior to execution shall become the responsibility of the Contractor.
 - Supervision if specifically asked would be provided but responsibility regarding correct & sound Construction shall solely rest with Contractor/Builder.
 - All relevant samples to be approved by architect prior to procurement.
 - M/s AT Technolegal Combine Pvt. Ltd. holds no responsibility regarding the design and quality of work already executed at Site.

S.no.	AREAS	CARPET AREA	
		SQM	SQFT
1	ENTRANCE LOBBY	8.23	88.5548
2	BANK MANAGER CABIN	10.24	110.1824
3	WORK STATIONS 1 & 2 AND STORAGE	10.6	114.056
4	WORK STATIONS 3 AND STORAGE	3.3	35.508
5	WORK STATIONS 4 AND STORAGE	4.8	51.688
6	CASH COUNTER	4.3	46.268
7	CUSTOMER LOBBY	24.3	261.468
8	BACK SIDE LOBBY	7.2	77.472
9	M. TOILET	2.4	25.824
10	F. TOILET	1.9	20.444
11	TOILET COMMON AREA	1.5	16.14
12	STORE ROOM	11.2	120.512
13	STRONG ROOM	13.46	144.8296
14	UPS ROOM	2.5	26.9
15	BORE HOLE	4.2	45.192
16	PANTRY	0.9	9.684
17	ATM	5.8	62.408
TOTAL CARPET AREA		116.83	1257.091
TOTAL COVERED AREA		127.38	1370.609

PROJECT TITLE

INTERIORS FOR BRANCH KHARORA,
DISTT. FATEHGARH SAHIB, PUNJAB

CLIENT

PUNJAB AND SIND BANK

ARCHITECTS

A.T. TECHNOLEGAL COMBINE
PRIVATE LIMITED
BL-63, SECTOR-116, NOIDA (UP)
MOBILE: +91-9999717558, +91-8285110902
E-MAIL: ATTLCP@GMAIL.COM

REVISION NOTES

NO	DATE	REVISION REMARKS	SIGN

DATE 10/09/2026

SCALE NTS

DEALT BY GARIMA

CHECKED BY TAPAN GOYAL

ATT/2025/PSB/CHZ/KHR/ELEC/FA-3R1

DRAWING TITLE

ELECTRICAL LAYOUT

FOR APPROVAL

COPYRIGHT

All designs & drawings are the property of A.T. Technolegal Combine Private Limited and cannot be used without their written approval.